


Plotted By: Botts, Nick Sheet: Sat:N JUPITER WATERMAIN IMPROVEMENTS Layout: C-01.E DRAINAGE PLAN March 24, 2016 03:56:38pm K:\web_civil\044001129_north_jupiter_wm\cadd_finao_design\Civil_3D\plansheets\C-01.E PLANSHEET.dwg
 This document, together with the concepts and designs presented herein, is intended only for the specific purpose and client for which it was prepared. Reuse of any information contained herein for any other purpose without the express written authorization and approval of Kimley-Horn and Associates, Inc. shall be without liability to Kimley-Horn and Associates, Inc.

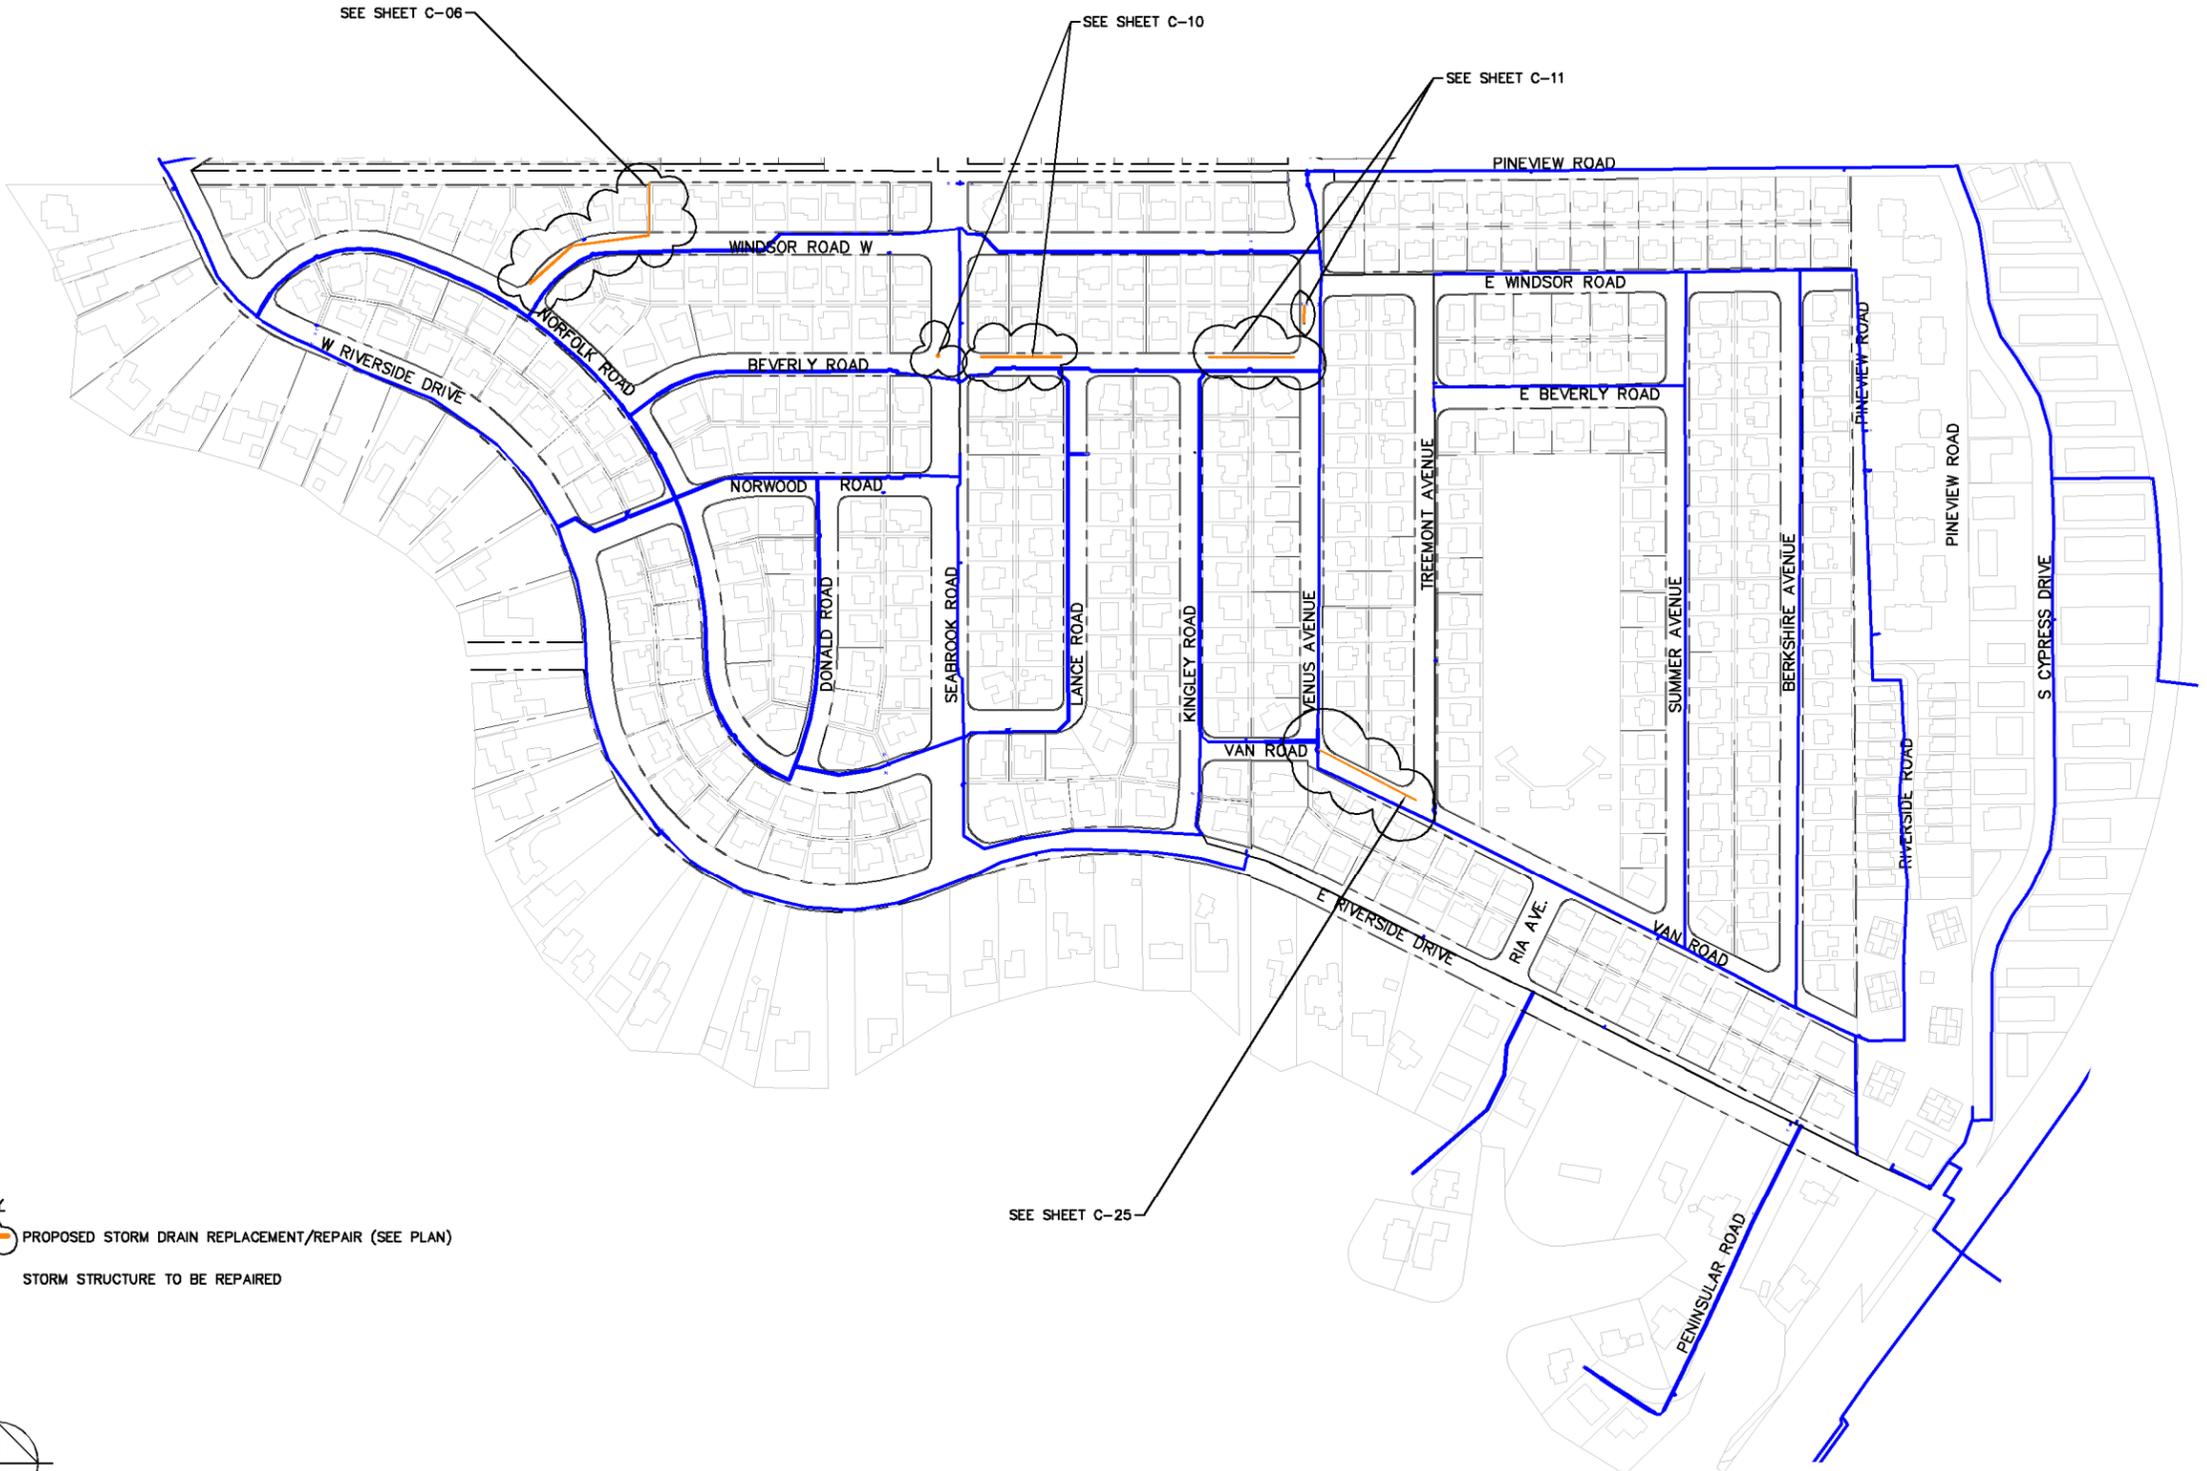

KEY

- PROPOSED STORM DRAIN REPLACEMENT/REPAIR (SEE PLAN)
- STORM STRUCTURE TO BE REPAIRED

GRAPHIC SCALE IN FEET

NORTH

CONFORMED SET

CALL 2 WORKING DAYS BEFORE YOU DIG
 IT'S THE LAW! DIAL 811
 Know what's below. Call before you dig.
SUNSHINE STATE ONE CALL OF FLORIDA, INC.

No.	REVISIONS	DATE	BY

Kimley»Horn

© 2016 KIMLEY-HORN AND ASSOCIATES, INC.
 1920 WEKIVA WAY SUITE 200, WEST PALM BEACH, FL 33411
 PHONE: 561-845-0665 FAX: 561-863-8175
 WWW.KIMLEY-HORN.COM CA 00000696

KHA PROJECT	044001129
DATE	JAN. 2016
SCALE	AS SHOWN
DESIGNED BY	AKP
DRAWN BY	TSH
CHECKED BY	JRL

NORTH JUPITER WATERMAIN IMPROVEMENTS
 PREPARED FOR TOWN OF JUPITER

PALM BEACH FLORIDA

LICENSED PROFESSIONAL
ANJULI K. PANSE
FLORIDA LICENSE NUMBER
70251
DATE: _____

DRAINAGE PLAN

SHEET NUMBER
C-01.E